

 

# PENNSYLVANIA GAME COMMISSION

## PROJECT NO. PGC-062-25-01

### STATE GAME LANDS #062

### NEW FUEL STORAGE TANK

#### HAMLIN TOWNSHIP, McKEAN COUNTY, PENNSYLVANIA

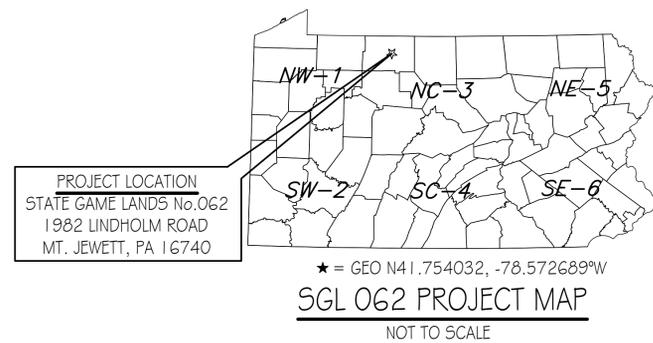


#### DRAWING INDEX

- CS-1 COVER SHEET
- SP-1 OVERALL SITE PLAN
- A-1 DEMOLITION/REMOVAL PLAN
- A-2 PLANS & DETAILS



<b>PENNSYLVANIA GAME COMMISSION</b>		
STATE GAME LANDS # 062	UNION TOWNSHIP	CLEARFIELD CTY.
NEW FUEL STORAGE TANK		
COVER SHEET		
REVISIONS	PROJECT NO.	PGC-062-25-01
	DRAWN BY:	Z. WHITENIGHT
	DATE:	9/29/2025
	SHEET NO.	CS-1

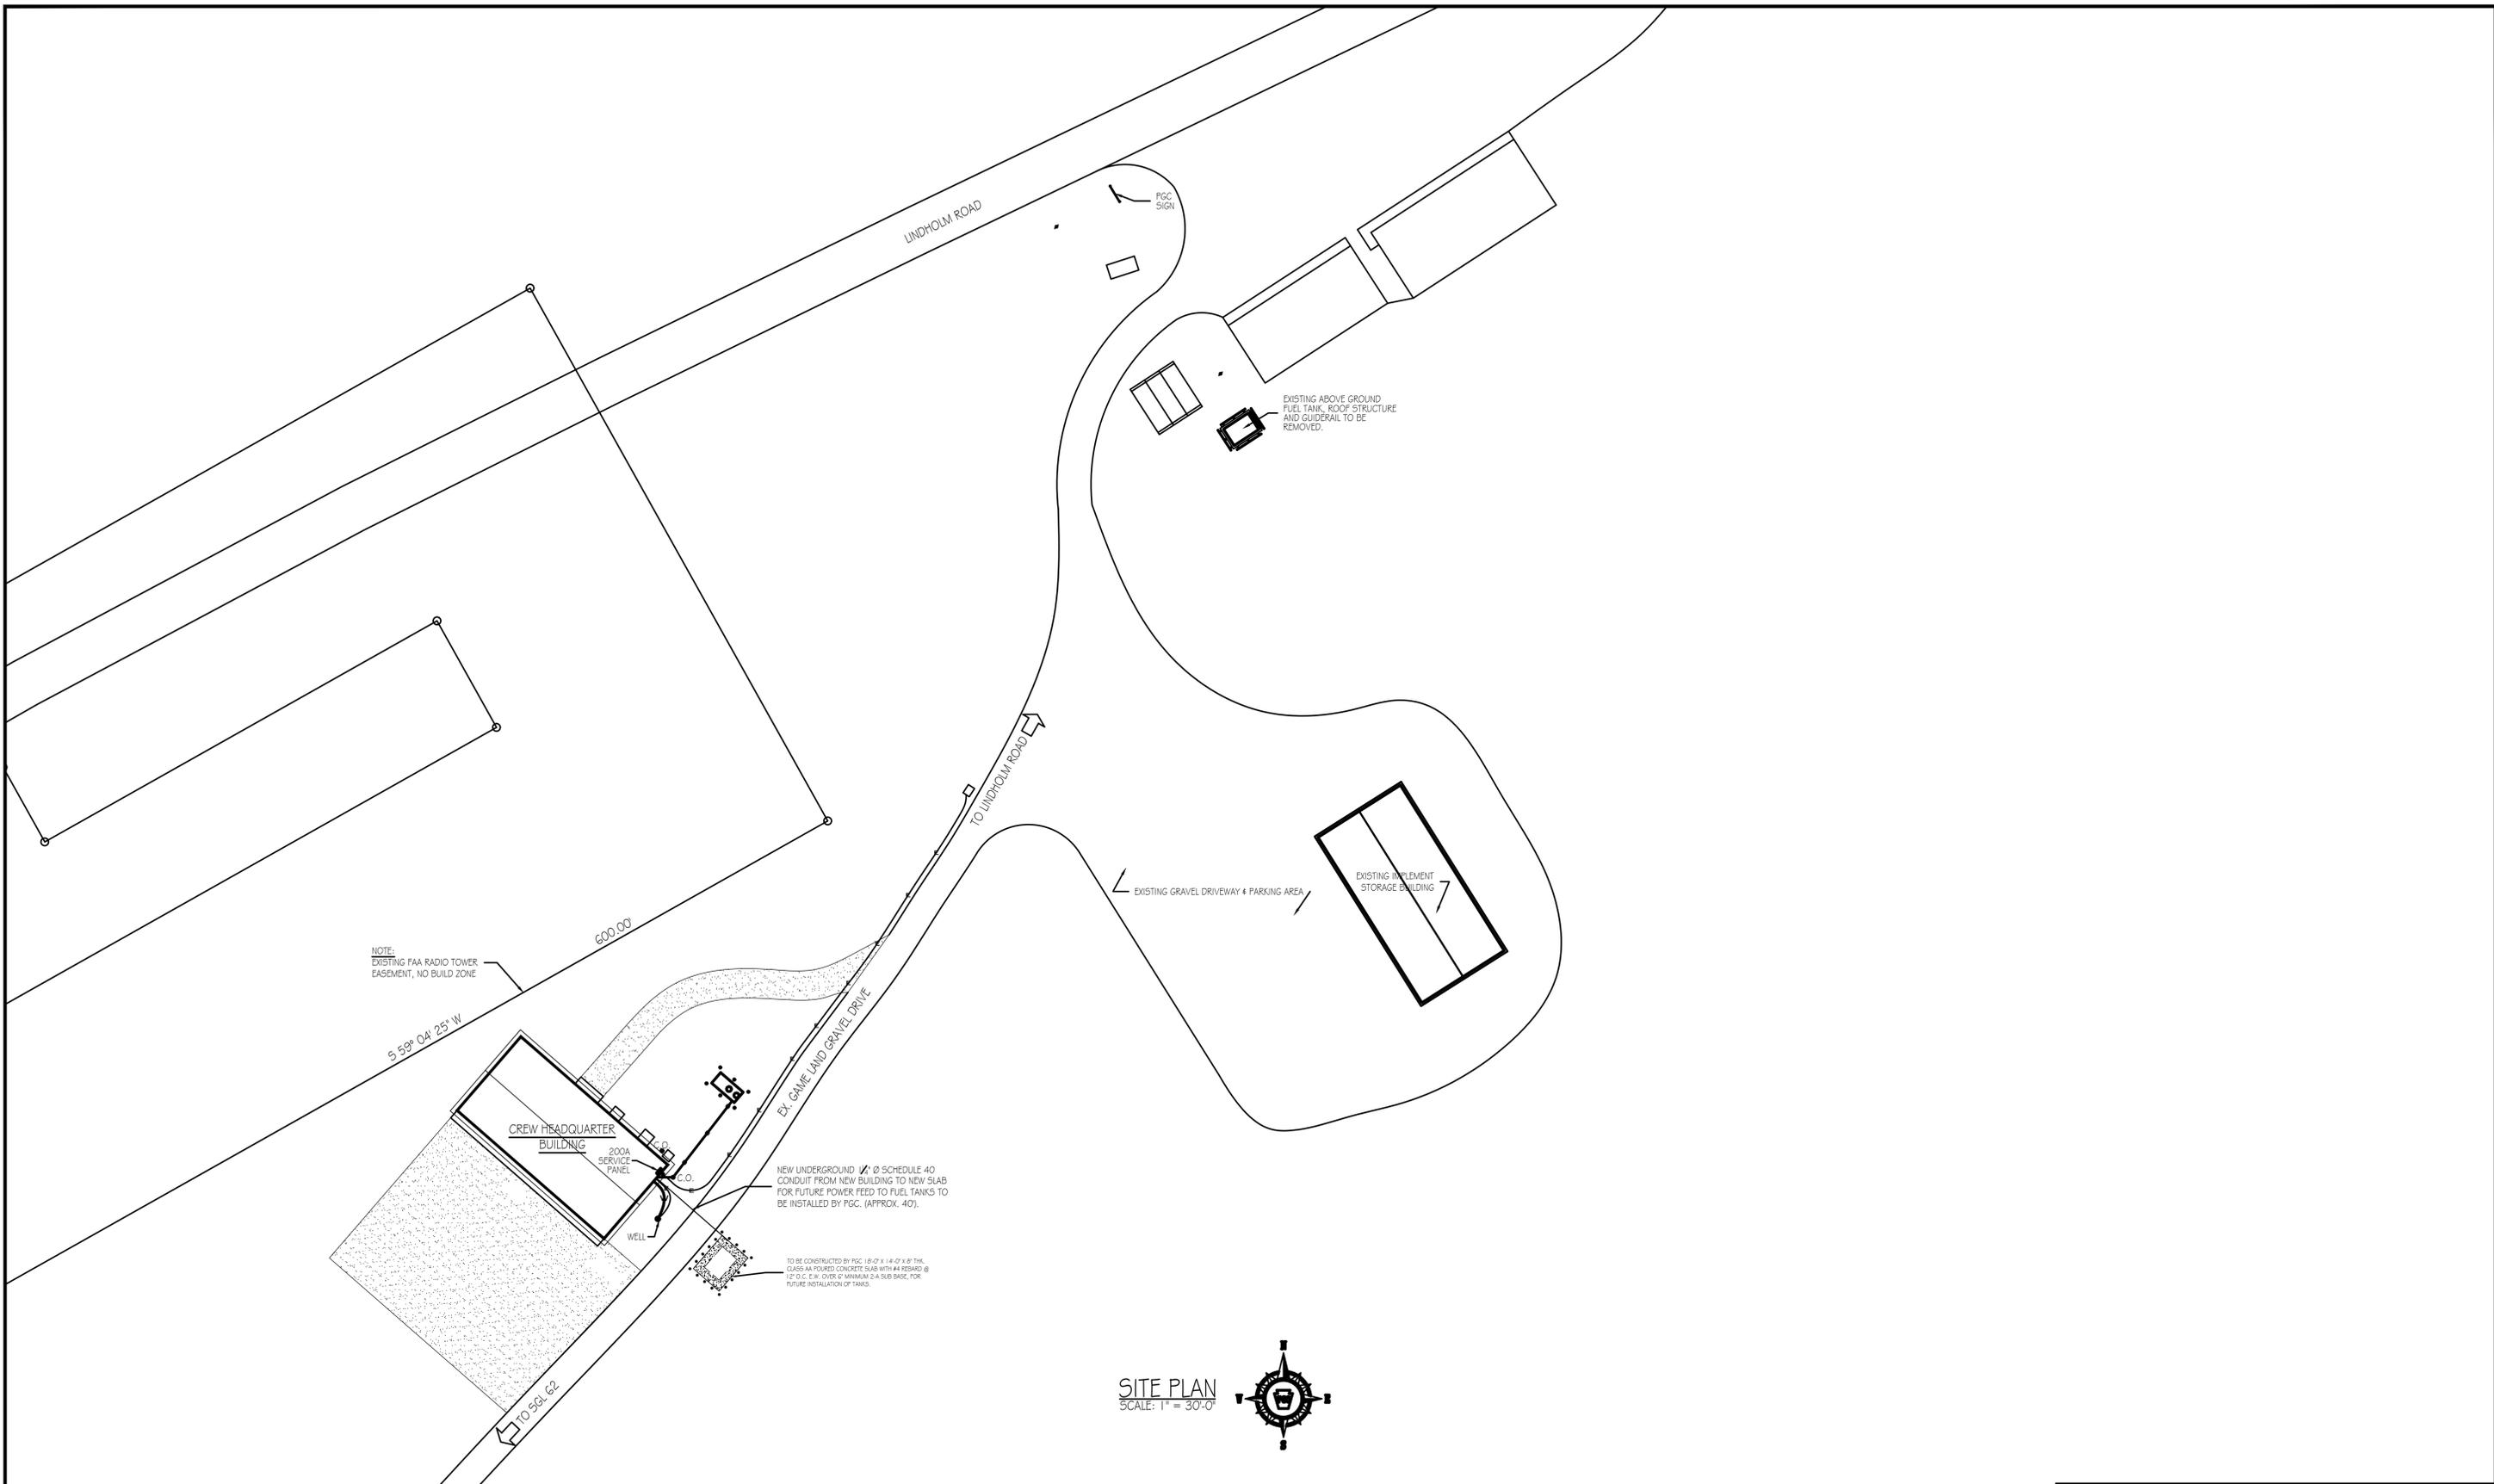

NOTE:  
EXISTING FAA RADIO TOWER  
EASEMENT, NO BUILD ZONE

5 59' 04" 25" W

600.00'

CREW HEADQUARTER  
BUILDING

200A  
SERVICE  
PANEL

WELL

NEW UNDERGROUND 1/2" Ø SCHEDULE 40  
CONDUIT FROM NEW BUILDING TO NEW SLAB  
FOR FUTURE POWER FEED TO FUEL TANKS TO  
BE INSTALLED BY PGC. (APPROX. 40').

TO BE CONSTRUCTED BY PGC 18'0" X 14'0" X 8" THK.  
GLASS AN FURROED CONCRETE SLAB WITH #4 REBAR @  
12" O.C. L.W. OVER 6" MINIMUM 2-A SLAB BASE, FOR  
FUTURE INSTALLATION OF TANKS.

LINDHOLM ROAD

PGC  
SIGN

EXISTING ABOVE GROUND  
FUEL TANK, ROOF STRUCTURE  
AND GUIDERAIL TO BE  
REMOVED.

EXISTING GRAVEL DRIVEWAY & PARKING AREA

EXISTING IMPLEMENT  
STORAGE BUILDING


TO LINDHOLM ROAD

TO 564.62

SITE PLAN  
SCALE: 1" = 30'-0"



PENNSYLVANIA GAME COMMISSION		
STATE GAME LANDS # 062	UNION TOWNSHIP	CLEARFIELD CTY.
NEW FUEL STORAGE TANK		
OVERALL SITE PLAN		
REVISIONS	PROJECT NO.	PGC-062-25-01
	DRAWN BY:	Z. WHITENIGHT
	DATE:	9/29/2025
	SHEET NO.	5P-1

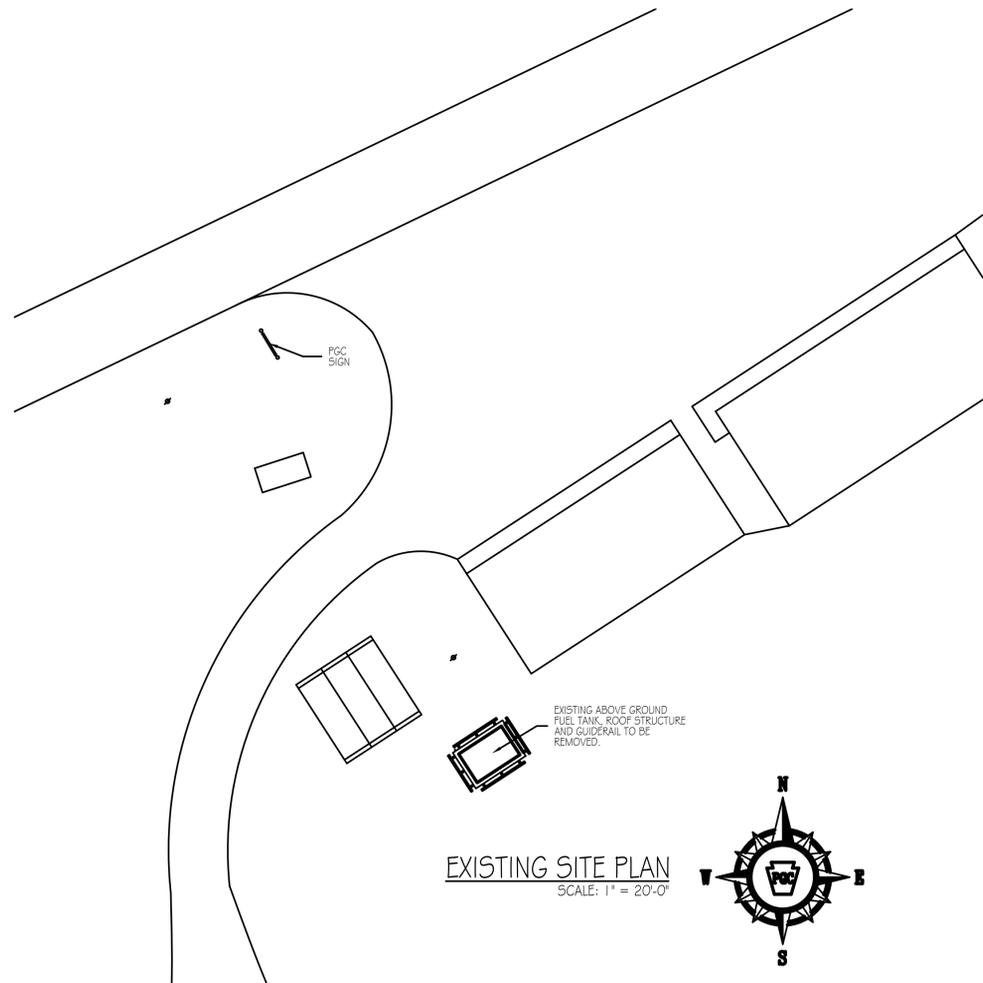





EXISTING FUEL TANK ELEVATIONS  
SCALE: NOT TO SCALE

DEMOLITION NOTES:

1. DEMOLISH THE EXISTING ROOF STRUCTURE AND REMOVE SUPPORT POSTS.
2. REMOVE EXISTING GUIDERAIL AND POSTS.
3. REMOVE EXISTING FUEL STORAGE TANK AND RELATED EQUIPMENT. CAP ELECTRICAL CONDUIT AT THE CONCRETE PAD AND DISCONNECT WIRING FROM INTERIOR POWER SUPPLY.



PENNSYLVANIA GAME COMMISSION		
STATE GAME LANDS # 062	UNION TOWNSHIP	CLEARFIELD CTY.
NEW FUEL STORAGE TANK		
DEMOLITION/REMOVAL PLAN		
REVISIONS	PROJECT NO.	PGC-062-25-01
	DRAWN BY:	Z. WHITENIGHT
	DATE:	9/29/2025
	SHEET NO.	A-1

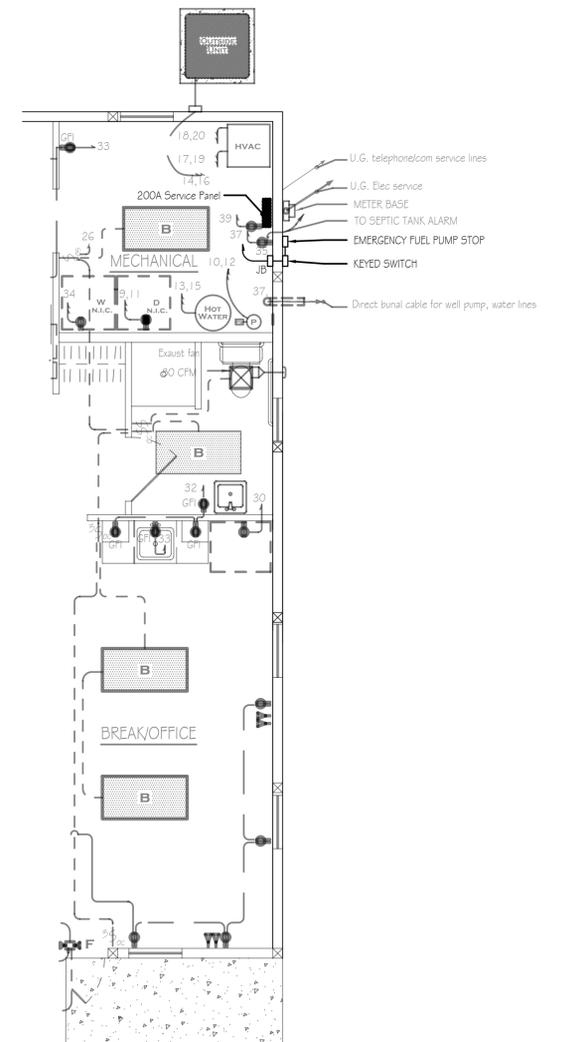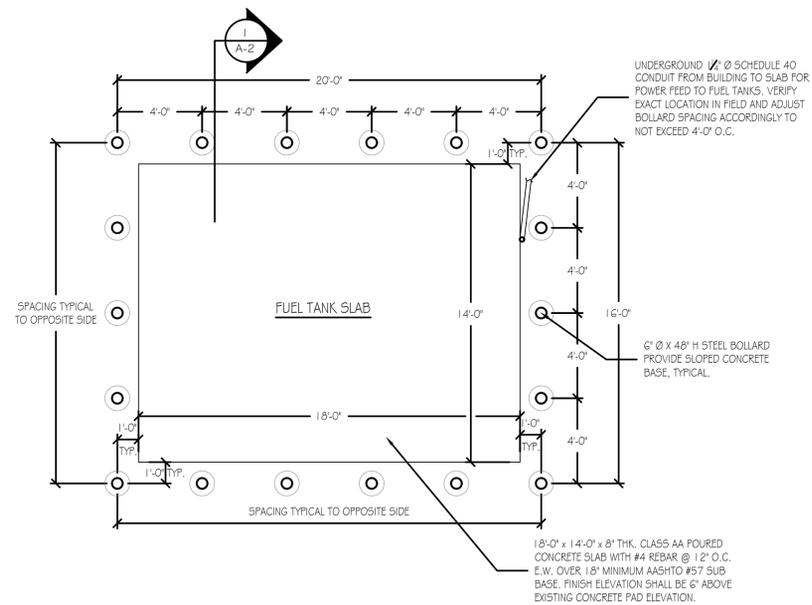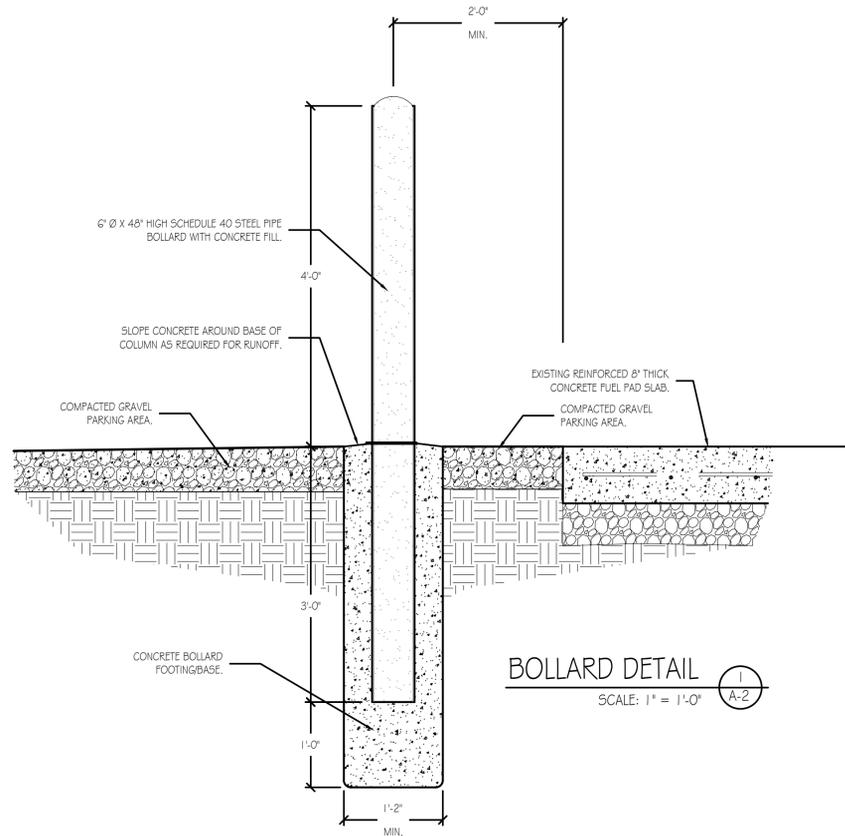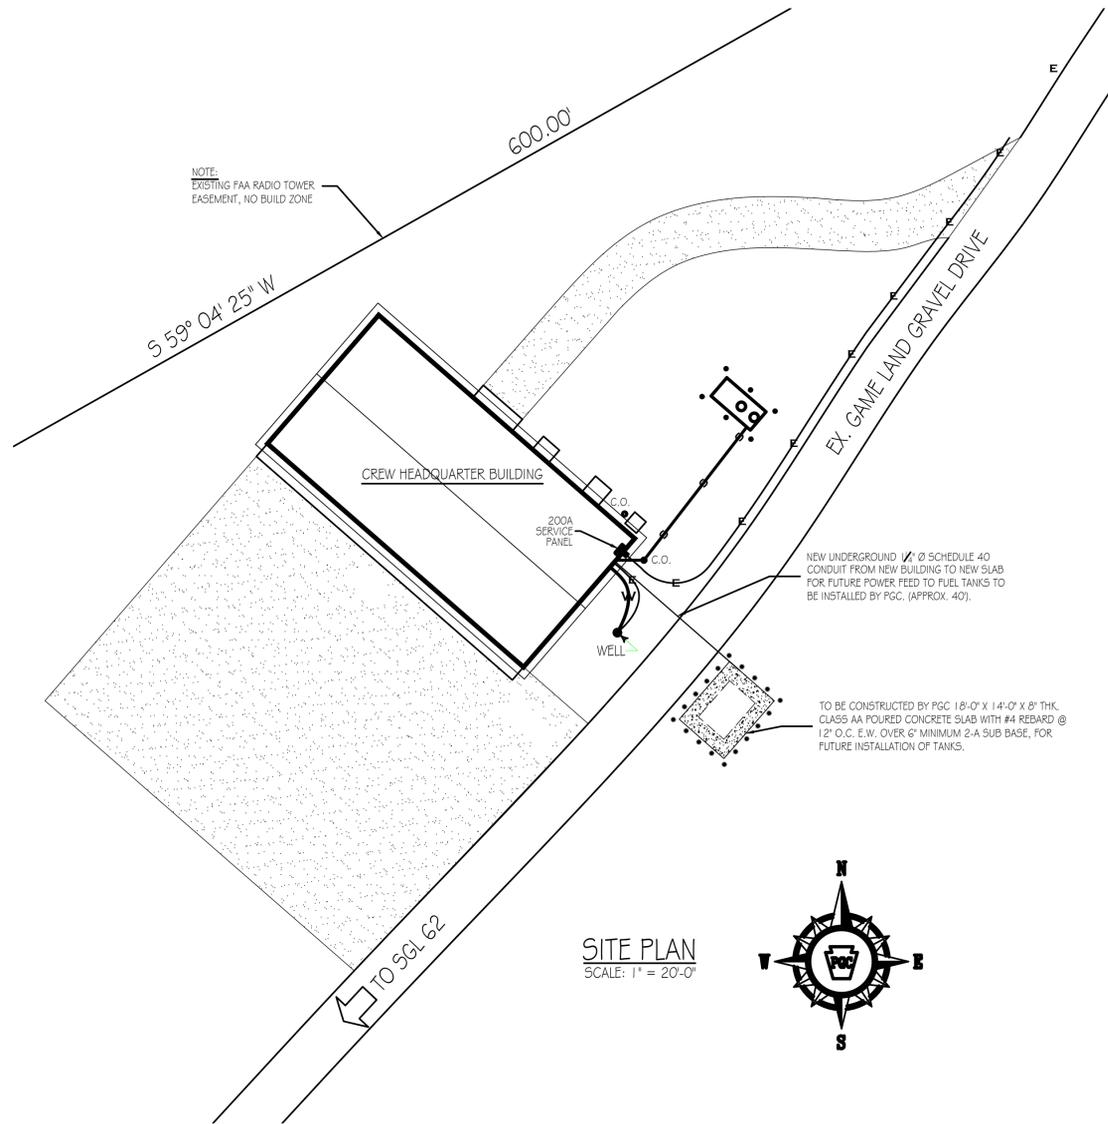

PARTIAL FLOOR PLAN - ELECTRICAL  
SCALE: 1/4" = 1'-0"



PENNSYLVANIA GAME COMMISSION		
STATE GAME LANDS # 062	UNION TOWNSHIP	CLEARFIELD CTY.
NEW FUEL STORAGE TANK		
PLANS & DETAILS		
REVISIONS	PROJECT NO.	PGC-062-25-01
	DRAWN BY:	Z. WHITENIGHT
	DATE:	9/29/2025
	SHEET NO.	A-2