


1 ENLARGED FLOOR PLAN - FEMALE LOCKER ROOM
SCALE: 3/8"=1'-0"





2 FEMALE RESTROOM ELEVATION
SCALE: 3/8"=1'-0"

3 ENLARGED FLOOR PLAN - FEMALE LOCKER ROOM
SCALE: 3/8"=1'-0"

10 ENLARGED FLOOR PLAN - FEMALE SAUNA
SCALE: 3/4"=1'-0"

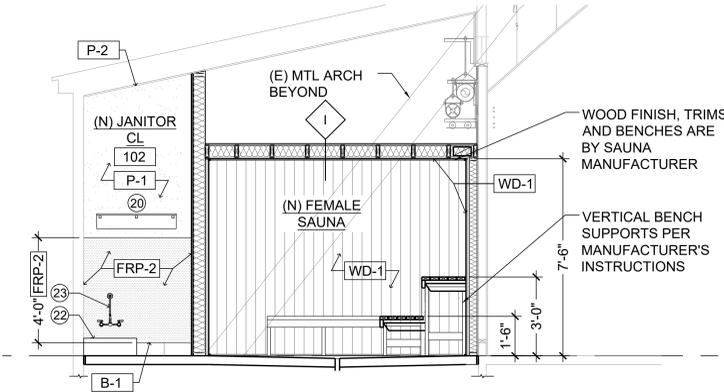

5 FEMALE RESTROOM ELEVATION
SCALE: 3/8"=1'-0"

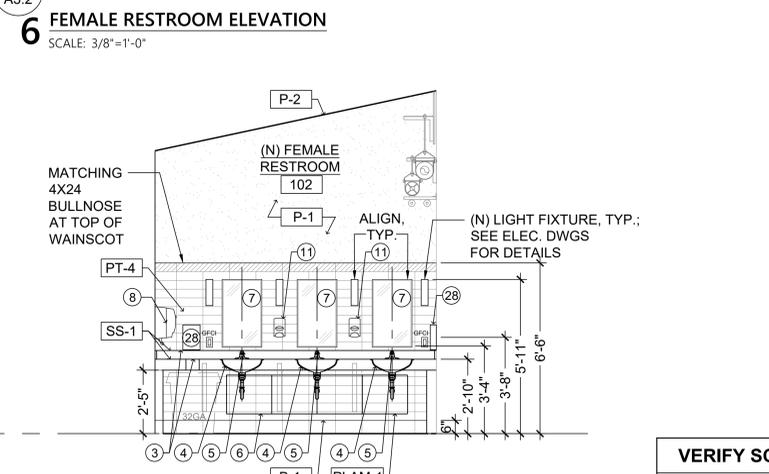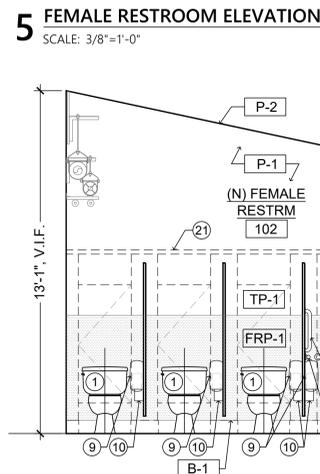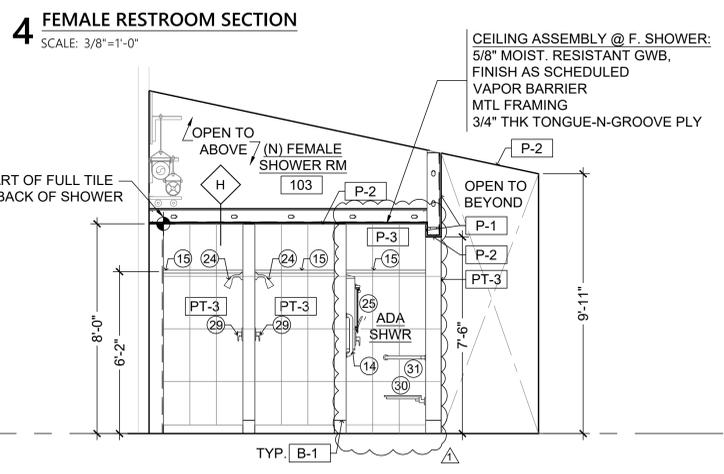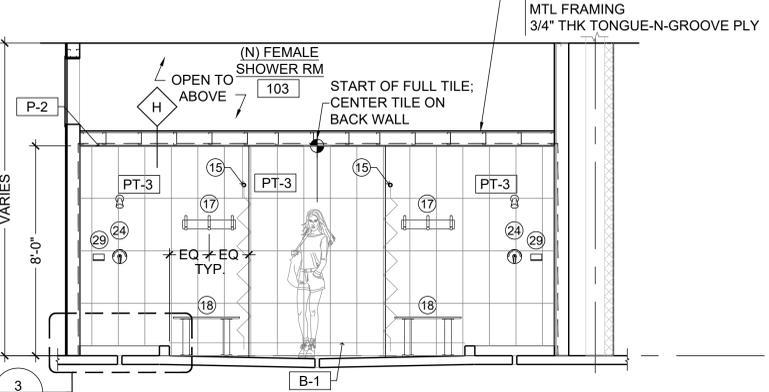


7 FEMALE RESTROOM ELEVATION
SCALE: 3/8"=1'-0"

8 FEMALE RESTROOM ELEVATION
SCALE: 3/8"=1'-0"

9 FEMALE RESTROOM ELEVATION
SCALE: 3/8"=1'-0"

ENLARGED PLAN NOTES
THE FOLLOWING NOTES PERTAIN THROUGHOUT BUILDING.
1. ALL DIMENSIONS ON ENLARGED PLANS ARE BETWEEN WALL FINISHES, UNLESS OTHERWISE NOTED.

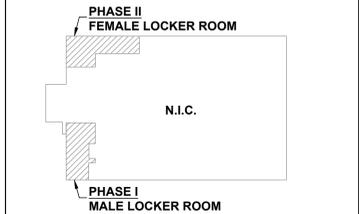

KEY PLAN
SCALE: N/A

REVISIONS

NO.	DESCRIPTION	DATE
ADDENDUM #5		1/9/2026

Professional's Signature _____ Date _____ Professional's Signature _____ Date _____
COMMONWEALTH OF PENNSYLVANIA
DEPT. OF MILITARY AND VETERANS' AFFAIRS
ANNVILLE, PENNSYLVANIA 17003

DESIGN PROFESSIONALS:
OFFICE OF FACILITIES AND ENGINEERING
BUREAU OF DESIGN AND PROJECT MANAGEMENT
BUILDING 0-10, CHAPEL ROAD, FORT INDIANTOWN GAP
ANNVILLE, LEBANON COUNTY, PENNSYLVANIA


DMVA PROJECT NO.: 42220103

FTIG - BLUE MOUNTAIN GYM
RENO PHASE 2
4-117 SPORTS ARENA
FORT INDIANTOWN GAP, ANNVILLE, PA 17003


ENLARGED PLANS AND ELEVATIONS

VERIFY SCALE
BAR IS ONE (1) INCH LONG ON ORIGINAL DRAWING:
0 1
IF BAR IS NOT ONE (1) INCH LONG, ADJUST SCALE ACCORDINGLY


DRAWN BY AK	DATE 13 Nov 2025	DRAWING NO. A3.0
CHECKED BY JN	SCALE AS NOTED	

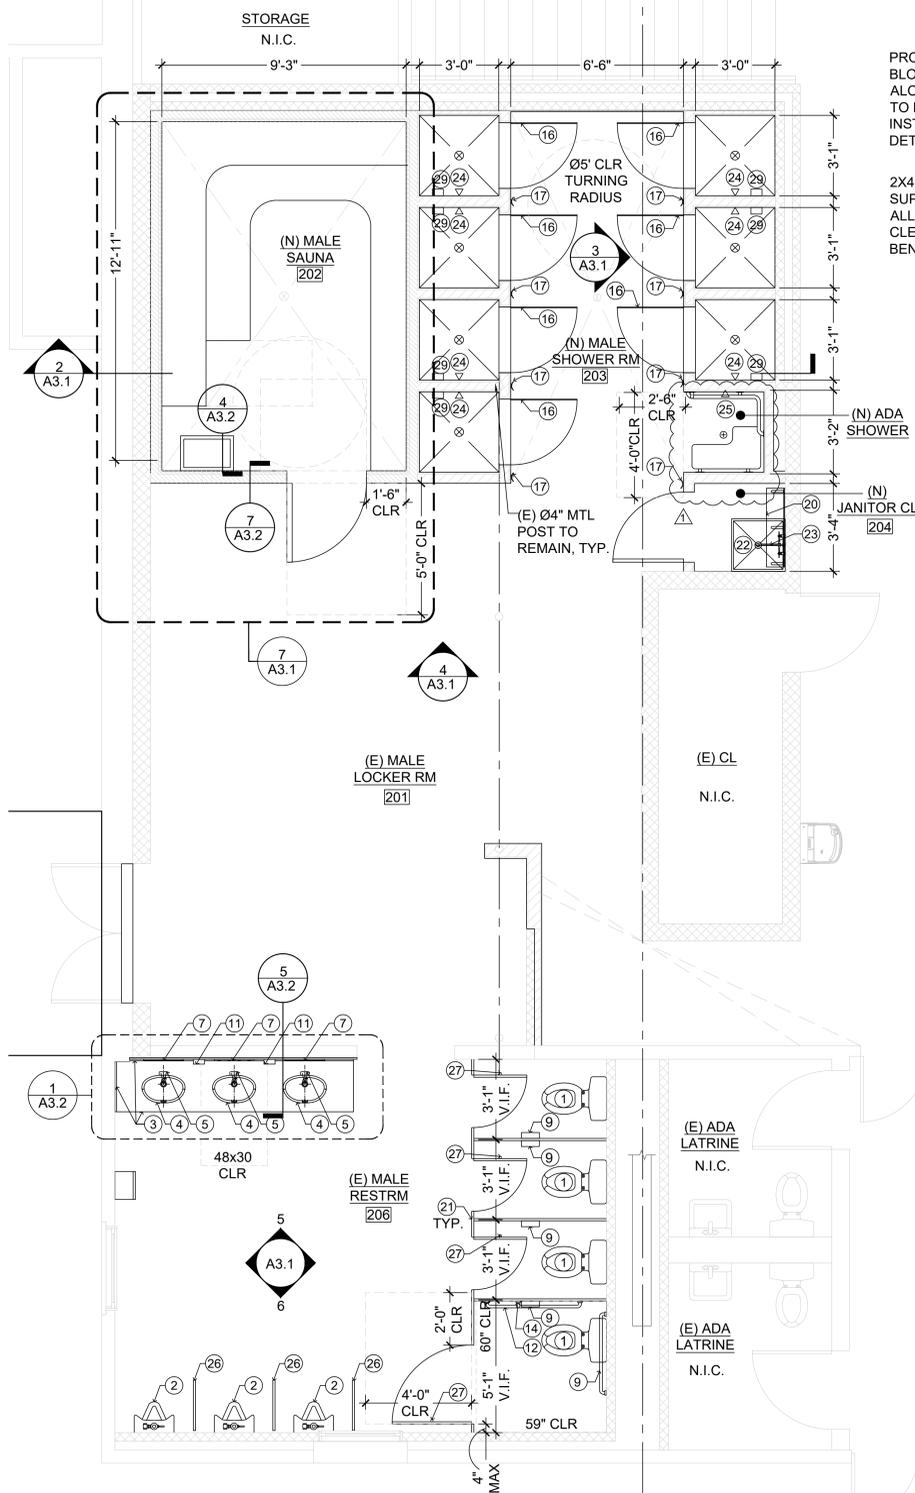


1 ENLARGED FLOOR PLAN - MALE LOCKER ROOM
SCALE: 3/8"=1'-0"

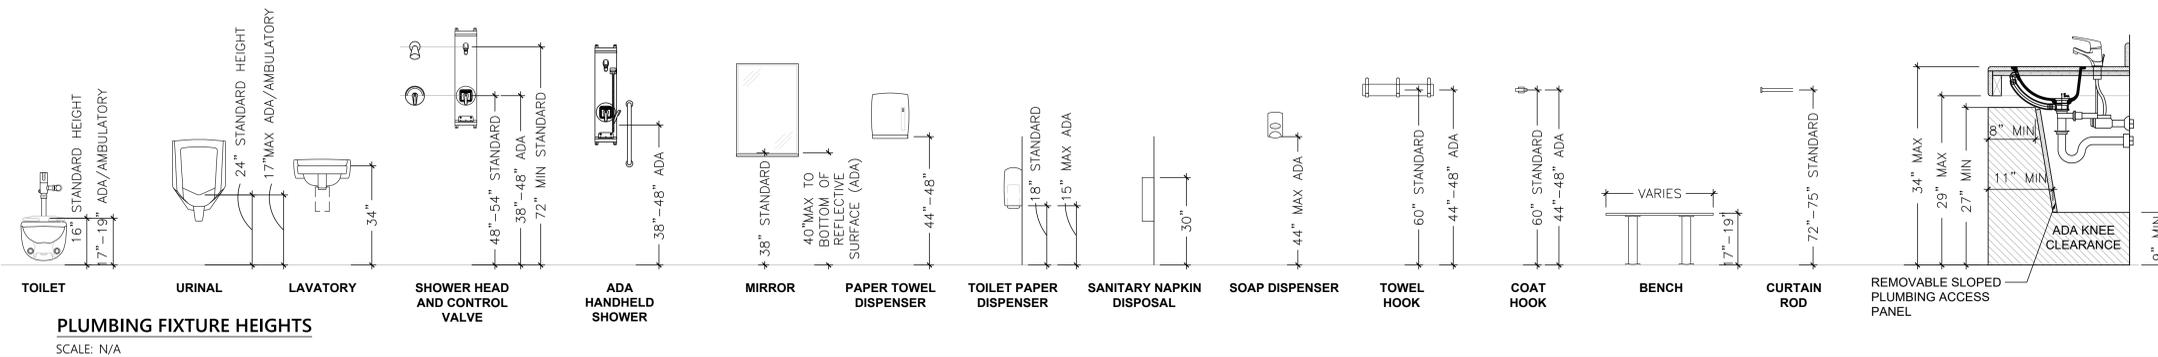


PLUMBING FIXTURE HEIGHTS
SCALE: N/A

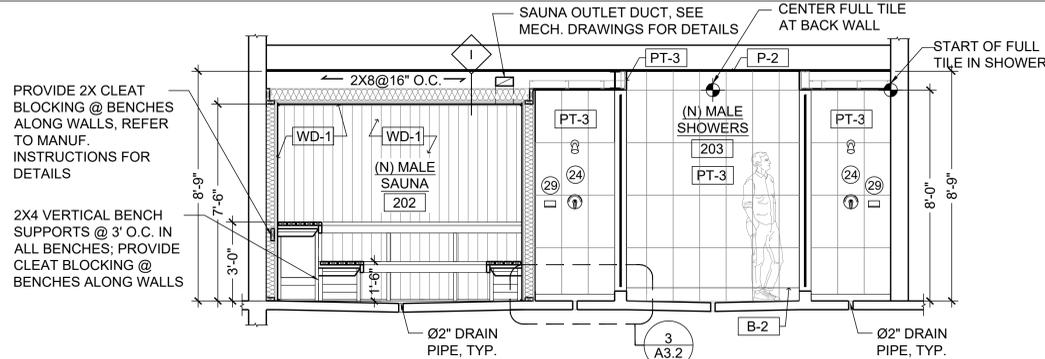


2 MALE SHOWER / SAUNA RM SECTION
SCALE: 3/8"=1'-0"

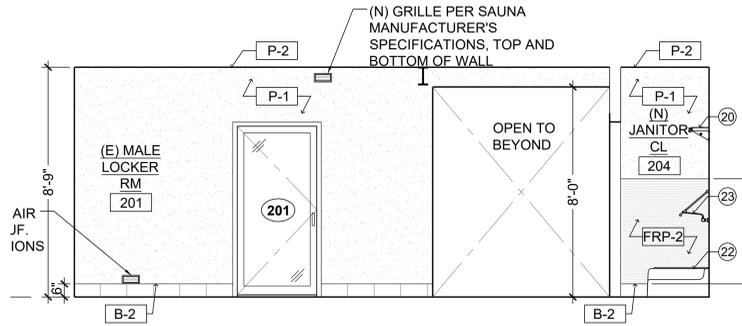


4 MALE LOCKER RM ELEVATION
SCALE: 3/8"=1'-0"

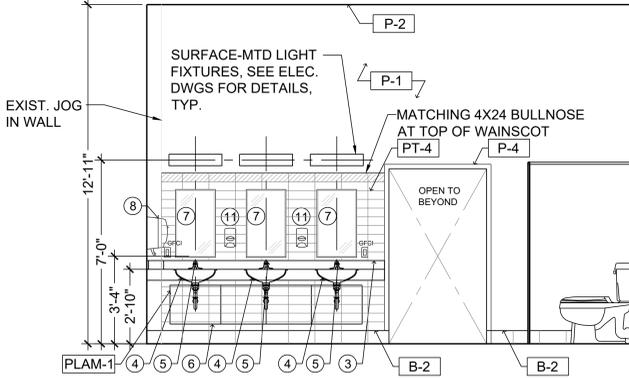


5 MALE RESTROOM ELEVATION
SCALE: 3/8"=1'-0"

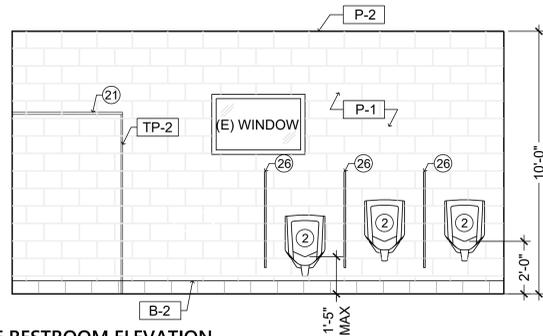


6 MALE RESTROOM ELEVATION
SCALE: 3/8"=1'-0"

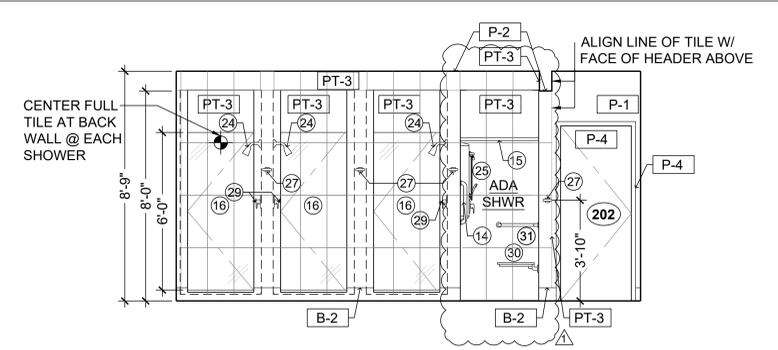

3 MALE SHOWER RM ELEVATION
SCALE: 3/8"=1'-0"

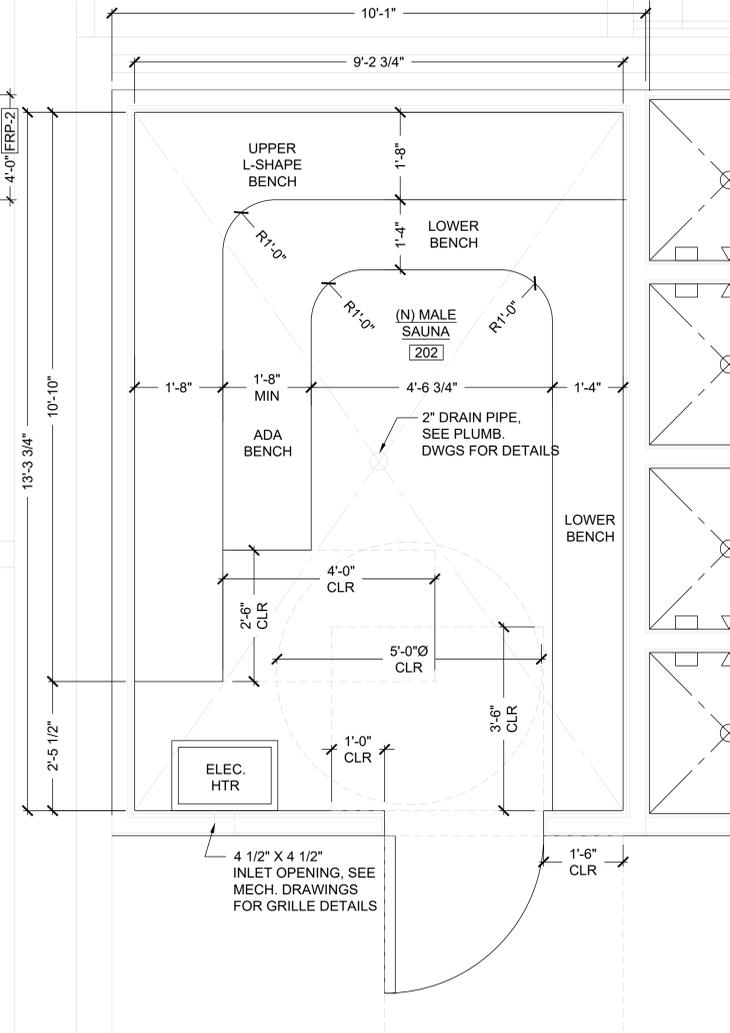

7 ENLARGED FLOOR PLAN - MALE SAUNA
SCALE: 3/8"=1'-0"

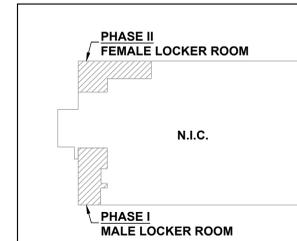

KEY PLAN
SCALE: N/A

REVISIONS

NO.	DESCRIPTION	DATE
1	ADDENDUM #5	1/9/2026

Professional's Signature _____ Date _____ Professional's Signature _____ Date _____
COMMONWEALTH OF PENNSYLVANIA
 DEPT. OF MILITARY AND VETERANS AFFAIRS
 ANNVILLE, PENNSYLVANIA 17003

DESIGN PROFESSIONALS:
 OFFICE OF FACILITIES AND ENGINEERING
 BUREAU OF DESIGN AND PROJECT MANAGEMENT
 BUILDING 0-10, CHAPEL ROAD, FORT INDIANTOWN GAP
 ANNVILLE, LEBANON COUNTY, PENNSYLVANIA

DMVA PROJECT NO.: 42220103
FTIG - BLUE MOUNTAIN GYM
RENO PHASE 2
 4-117 SPORTS ARENA
 FORT INDIANTOWN GAP, ANNVILLE, PA 17003

VERIFY SCALE
 BAR IS ONE (1) INCH LONG ON ORIGINAL DRAWING:
 0 1
 IF BAR IS NOT ONE (1) INCH LONG, ADJUST SCALE ACCORDINGLY

ENLARGED PLANS AND ELEVATIONS
 DRAWN BY: AK
 CHECKED BY: JN
 DATE: 13 Nov 2025
 SCALE: AS NOTED
A3.1